




NOT TO SCALE

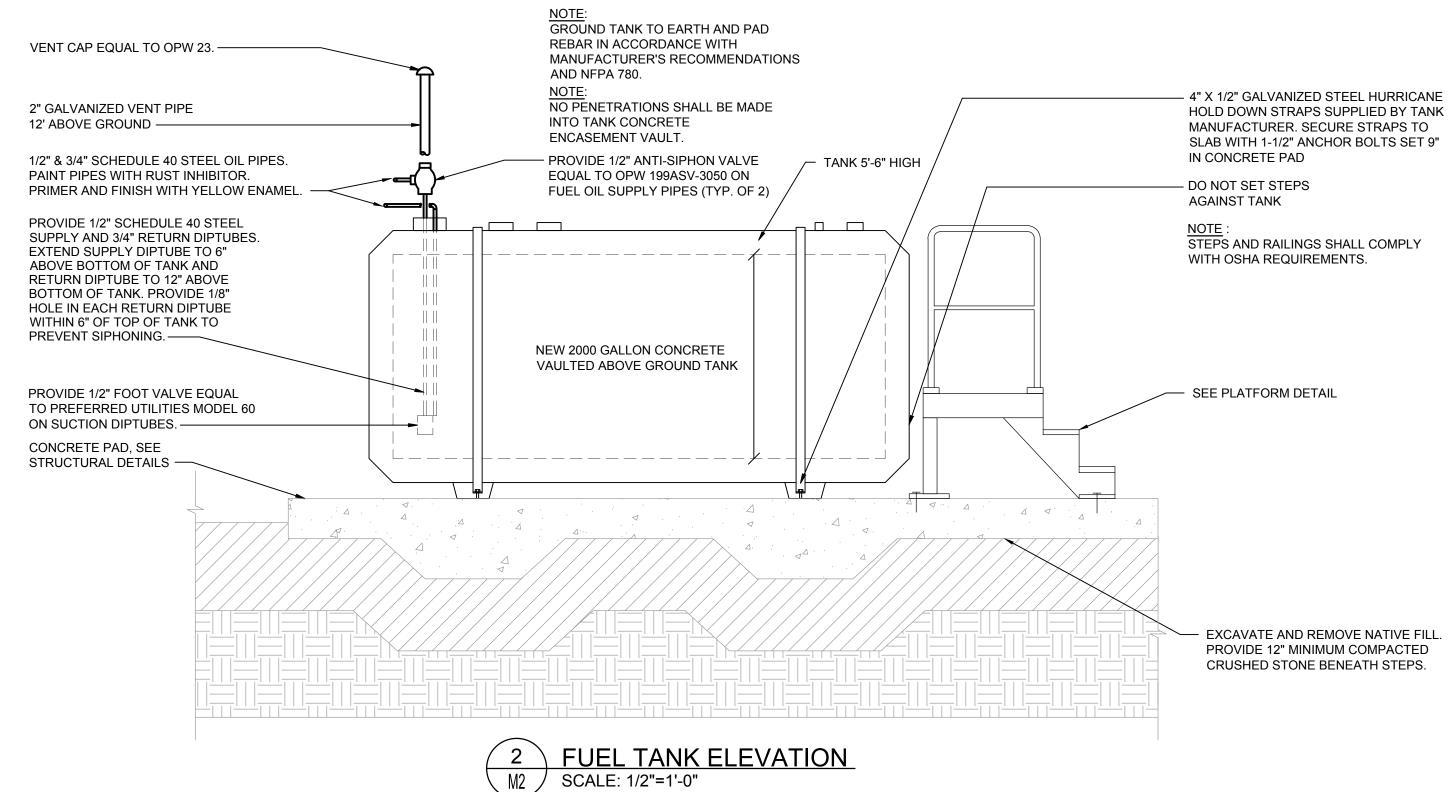

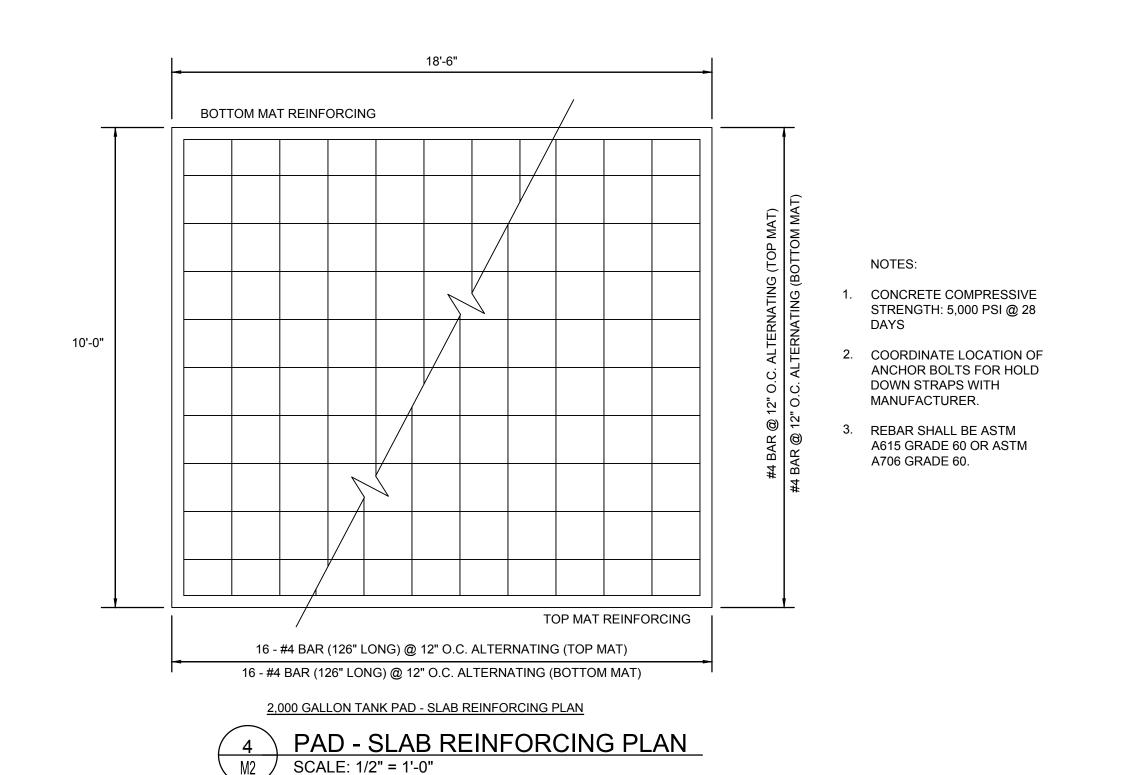

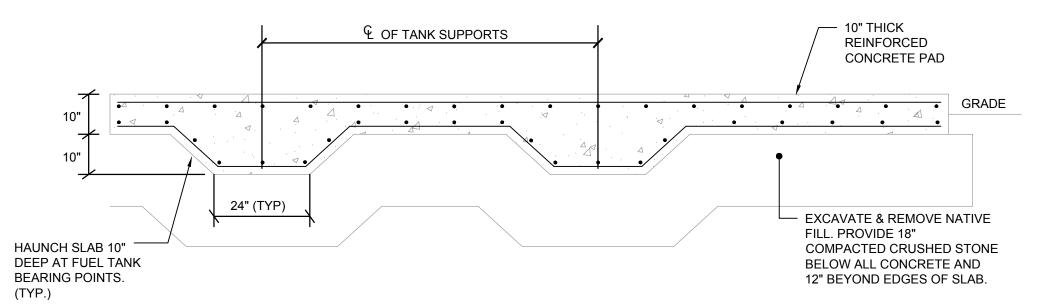

6 SECTION THRU TANK PAD

M2 SCALE: 1/2"=1'-0"



SEAL

CONSULTANTS

SUBMISSION HISTORY

JOB INFO

OIL TANK REPLACEMENT for

Former Orchard Hill School **Present P.R. Smith** School

South Windsor, CT

19-304

AS NOTED

DWG DATA

PROJECT NUMBER: SUBMISSION DATE: 08/07/2019 DRAWN:

REVIEWED: SCALE:

DWG TITLE

MECHANICAL DETAILS

DWG #